


Uniontown Baptist Church Bathroom Renovation Plan

24-1555

RECEIVED

DFG 8 2025

MIDDLE EAST 5110
BUILDING DEPT.

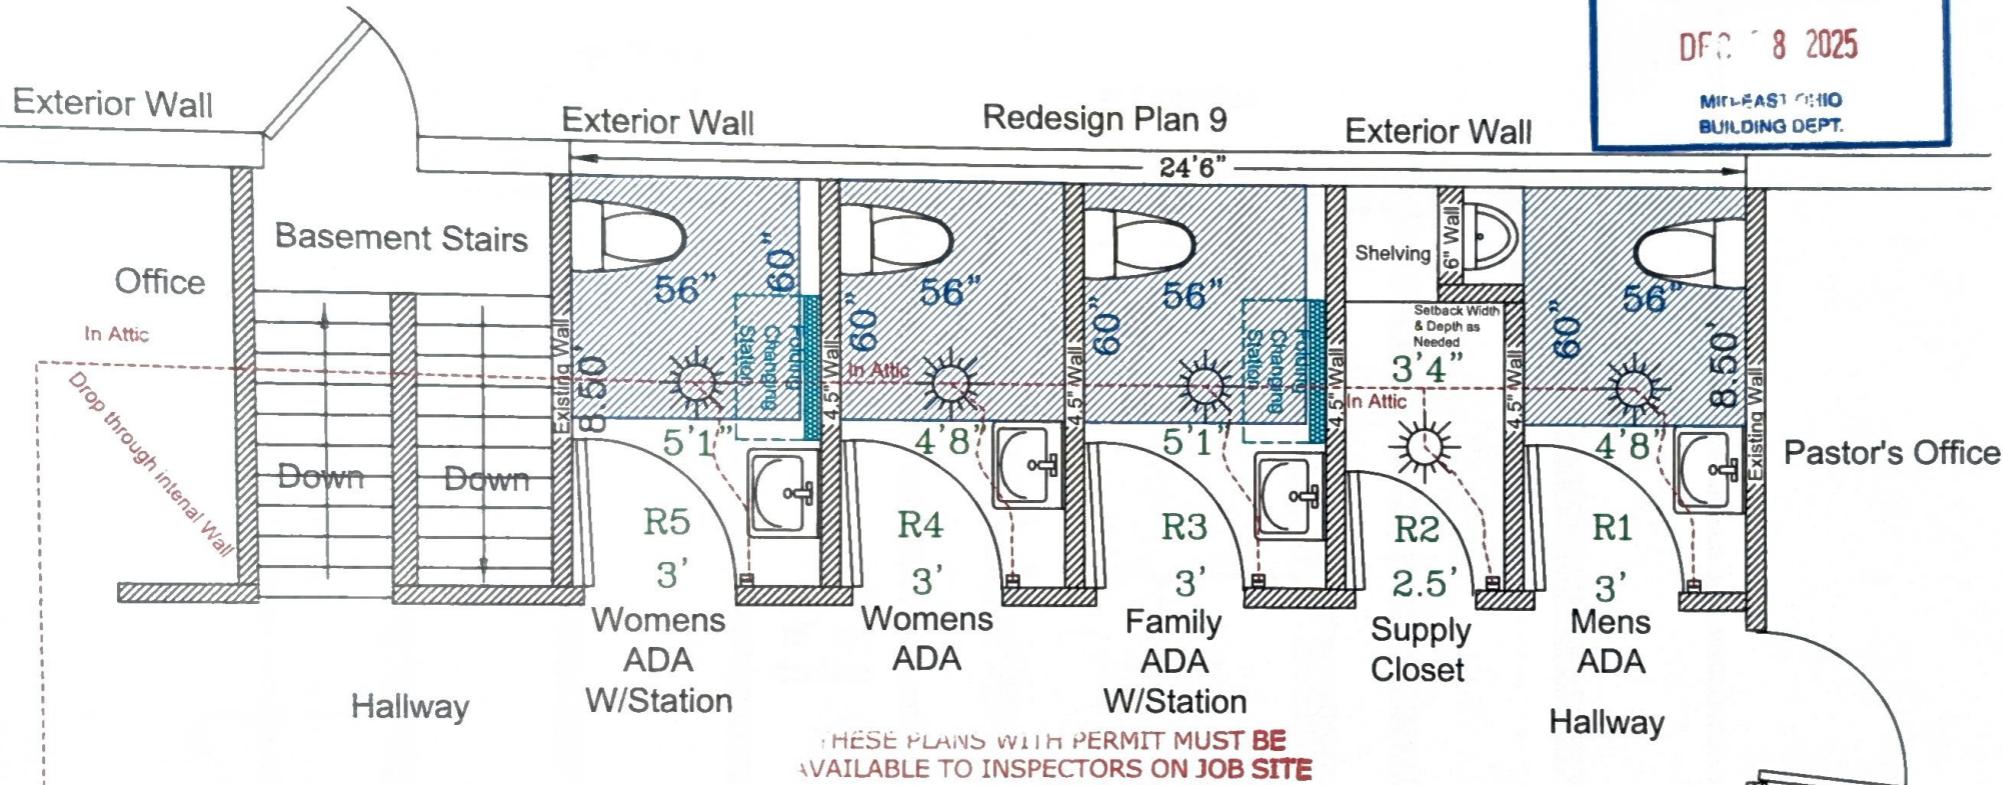

THESE PLANS WITH PERMIT MUST BE
AVAILABLE TO INSPECTORS ON JOB SITE
CALL FOR INSPECTIONS 740-455-7905

Classroom

OTHER APPROVALS REQUIRED

Check with Local Officials Zoning Approval, Storm Water Runoff Approval, Floodplain Administration Approval, Fire Department Review, Local Building Permit may be required before construction

Entrance Hallway

MID-EAST OHIO
BUILDING DEPARTMENT
APPROVED AS NOTED
BY: Jasen Baugh
DATE: 12/15/2025

Classroom

CITE

Located in Basement

Electrical Panel

Construction Order:
Build Room I prior to demolition of existing
Men's and Women's Restrooms for use
during remaining construction:

Construction Plan:
Current Space Men's, Women's Restrooms,
Closet, 210 square feet
New Internal Walls using drywall bathroom
rated (See Diagram)
Repair floor plywood as needed.
Ceiling Tile to be removed Replaced with
drywall bathroom rated .
Existing Fiberglass Insulation rolled back
and reused if possible, replaced as needed.
Replace existing flooring with new vinyl
flooring.
Steel entry doors with locking level handles.

Plumbing Plan:
ADA Complaint (See Diagram) Including
Grab Bars, Wall Sinks, Urinal
Install required check flow valve on public
water line.

Electric Plan:
New dedicated circuit of 14/2 wire with ground to 5 new ceiling lights, switches, and 4 exhausted fans meeting minimal CFM requirements operated with ceiling light switch, vented through soffit.
No electrical outlets or dryers to be installed in Restrooms. Outlet to be installed in Supply Closet.

HVAC Plan:
Relocate 3 existing floor vents and install 2 additional floor vents.

Drawn By: Charles R Harkness
Deacon of Property
Date 12/8/2025